


DRAWING NAME: S:\PROJECTS\2203\HRM - SULLIVAN'S POND - PHASE 2\AS ISSUED\23-12-6 - OVERALL SD TO CBCL\2203\HRM - OVERALL LANDSCAPE DESIGN FULL - 23-DEC-6.DWG LAYOUT NAME: CONCEPT-LAYOUT WITH MP PLOT DATE: Thursday, December 7, 2023 9:51:24 AM CAD OPERATOR: MEHRNOSH

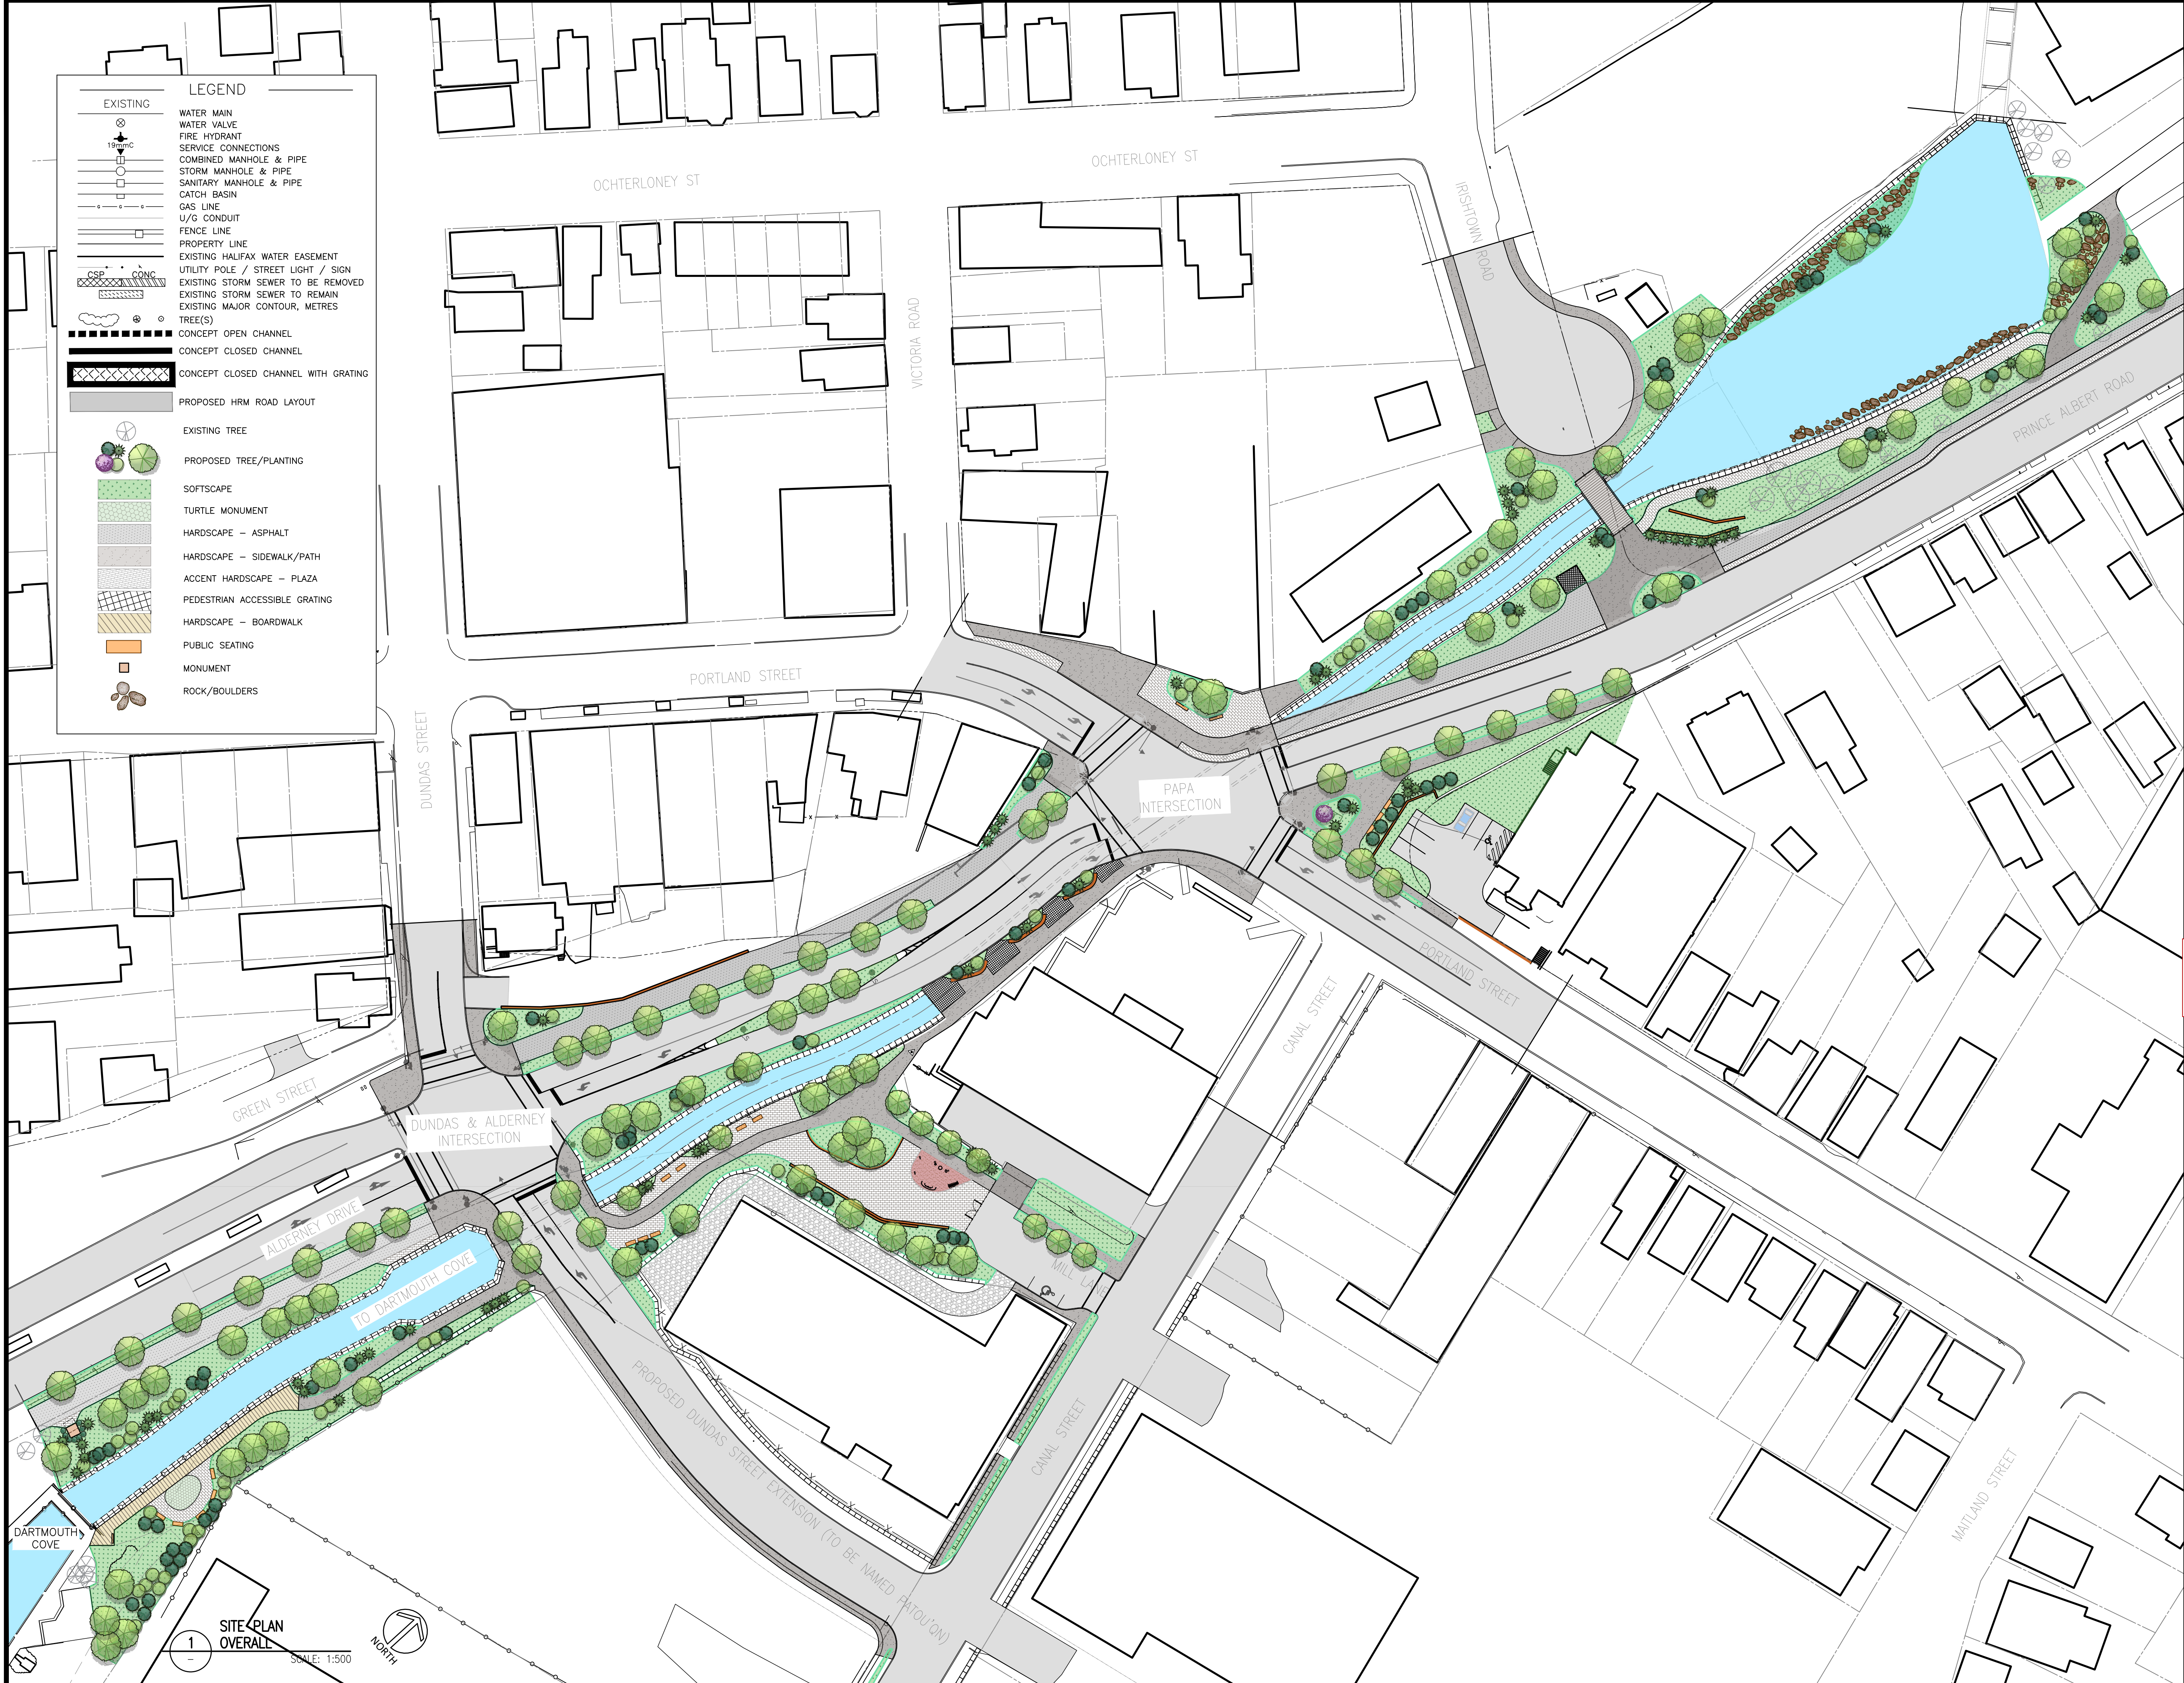

LEGEND

EXISTING

- WATER MAIN
- WATER VALVE
- FIRE HYDRANT
- SERVICE CONNECTIONS
- COMBINED MANHOLE & PIPE
- STORM MANHOLE & PIPE
- SANITARY MANHOLE & PIPE
- CATCH BASIN
- GAS LINE
- U/G CONDUIT
- FENCE LINE
- PROPERTY LINE
- EXISTING HALIFAX WATER EASEMENT
- UTILITY POLE / STREET LIGHT / SIGN
- EXISTING STORM SEWER TO BE REMOVED
- EXISTING STORM SEWER TO REMAIN
- EXISTING MAJOR CONTOUR, METRES
- TREE(S)

CONCEPT

- CONCEPT OPEN CHANNEL
- CONCEPT CLOSED CHANNEL
- CONCEPT CLOSED CHANNEL WITH GRATING
- PROPOSED HRM ROAD LAYOUT

EXISTING TREE

PROPOSED TREE/PLANTING

SOFTSCAPE

TURTLE MONUMENT

HARDSCAPE - ASPHALT

HARDSCAPE - SIDEWALK/PATH

ACCENT HARDSCAPE - PLAZA

PEDESTRIAN ACCESSIBLE GRATING

HARDSCAPE - BOARDWALK

PUBLIC SEATING

MONUMENT

ROCK/BOULDERS



Vollick McKee Petersmann
ASSOCIATES LIMITED

LANDSCAPE ARCHITECTURE
SITE PLANNING PROJECT MANAGEMENT


3008 Oxford Street
Suite 203
Halifax, Nova Scotia
Canada B3B 2V6

Tel: 902 422 6514
Fax: 902 422 9802
info@vollickmckee.com
www.vollickmckee.com

PRELIMINARY

5	ISSUED FOR 90% DESIGN REVIEW	23-12 15	MM	CV
4	ISSUED FOR PRELIMINARY REVIEW	23-09 7	MM	CV
3	ISSUED FOR SCHEMATIC REVIEW	23-03 28	MM	CV
2	ISSUED FOR SCHEMATIC REVIEW	23-02 28	MM	CV
1	ISSUED FOR SCHEMATIC REVIEW	23-02 24	MM	CV

No.	DESCRIPTION	DATE	BY	CHKD
-----	-------------	------	----	------

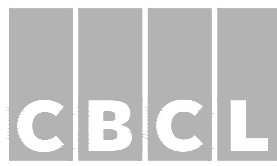

ENGINEERING DEPARTMENT

PROJECT

**CONCEPTUAL SAWMILL
CREEK ALIGNMENT - PAPA
INTERSECTION - OPTION 3**

DRAWN	MM	SCALE (PLAN)	1:500
CHECKED	CV	SCALE (PROFILE)	
APPROVED		DATE	DECEMBER 15, 2023
PROJECT No.	131025.07		
DWG. No.			